
aa aa aa ee ee oo aa	00 44 00 00 20 00 44 00	0.0 10-0.0 10-0.0 14 00	- 64 - 65 - 44 <u>- 86 - 66 - 66 - 66 - 6</u>	
the second se				1 10 00 10 -00 -01 17 00
		CHEEK DRIVE	11 10 23 20 12 10 23 1	
00 00 00 00 00 00 00 00			S. P	0 E4 12 01 44 00 EE 00
00 00 10 00 10 00	2 at at at at at at			a ter as as as as
00 00 as 10 00 00 100			20 20 10 1	a ada a a a a a a a a a a a a a a a a a
00 00 00 00 00 00	10 14 19 19 28 20	22 23 20 28 19 25 19 10	10 10 21 20 18 19 1	a sis of fail a second
00 00 47 00 49 00 🕈	1.5 1.8 2.1 2.0 22 2.1	21 22 21 22 21 22 19 18	20 21 21 18 23 2	4 24 1 2 2 00 00 00 00
199 - 00 - 00 - 100 - 90 - 90 - 90	14 20 21 21 21 24			
0,0 00 10 00 10 10 00	2 ////		15 21 24 21 21 21 23 2	
-00 65 84 00 0F 02 F		1 1 1 1 1 1 1 1 1 1 1 1 1 1 1 1 1 1 1	47 55 44 51 19 18 21 2	
				2 - 22
	24 38 31		7.7 22 63 14 4	/ / //
an an an an ar ar ar			35 10 23 0/2	11 - 11 - 11 - 11 - 11 - 11 - 11 - 11
	1.0 24 32 43 60 163 128 138	127/ 126 128 130 133 123 106 123		A. S.
0.0 0.0 0.0 0.0 0.0 0.0	11 23 25 45 45 53 51 47	4.4 4.6 50 58 58 57 54 53	53 42 23 11 m / 12 / 24	11 1 1 1 1 1 1
00 00 42 00 11 2 11	1.5 2.7 3.2 3.4 3.4 2.8 2.2 1.8	15 19 27 25 37 38 23 27	22 20 12	a par a a marte a
	10 23 29 25 18 19	14 23 29 34 44 48 37 33	··· · · · ////	1/21 a1/20 30/00 20/0
	7 39 34, 49 29, 37 10	20 10 , 22 36 79 . 53 , 34 30	m Re 1 1/1/1/1/	a and an and an an and an
00 00 92 00 68 50 100	1 2 208 20 58 70 70		/ / / y /	1 1 1 1 1 1 1 1 1 1 1 1 1 1 1 1 1 1 1
00 00 40 00 00 00 00			1 11 11 · /·	a coff as a coffee a
1 10 00 11 10 00 00 00 00			~~~ <u>C</u> []/// /~ /~	0 /63 95 00//10/00 66 0
00 00 00 00 00 00 00				e es an //c /an an se a
			THE SIN I	
				All to an an an
00 00 00 00 00 00 00				
as as and and as he as		1 August	/ finder	
00 00 10 to 00 00	2702 77 38 58 58 58 58	24 15 15 At 105 44	24 HILLING HILLING	1 1 1 00 00 00 00 00 0
00 00 400 00 00 00 00	5		- 00 00 EP 00 00 00 0	0 11 00 Place 00 11 0
00 00 B 00 B 00 B 00	A CONTRACTOR OF A DESCRIPTION OF A DESCR	00 11 00 14 18 00 11 60		
0.0 0.0 0.0 0.0 1.0 0.0 0.0 0.0		0.0 2.2 0.0 0.0 0.0 0.0 0.0 0.0	0.0 0.0 0.0 0.0 0.0 0.0 0.0	0 8.8 00 00 2.9 00 8.8 0
0.0 0.0 0.0 0.0 0.0 0.0 40	EAST, KING SIREET	00 - 44 - 00 - 64 - 92 - 00 - 44 - 02		0 23 00 00 22 00 23 0

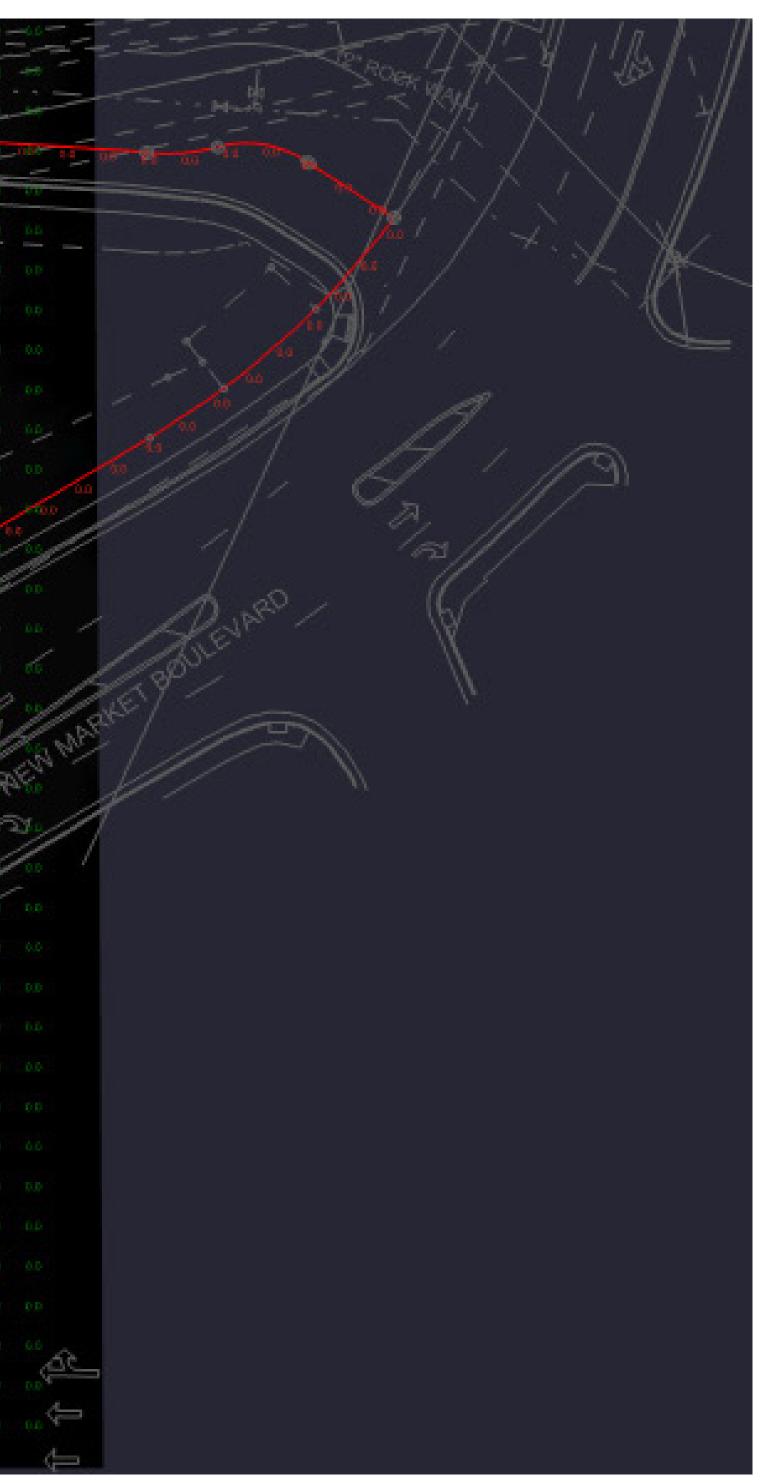



Issued 01/22/2024

ANY SITE PLAN(S), FLOOR PLAN(S), RENDERING(S), LIGHTING LAYOUT(S) AND PHOTOMETRIC PLAN(S) INCLUDING BUT NOT LIMITED TO ANY PROJECT(S) CREATED/PRODUCED BY RED LEONARD ASSOCIATES INC., ARE ONLY INTENDED FOR ILLUSTRATION AND QUOTING PURPOSES ONLY. RED LEONARD ASSOCIATES HAS THE RIGHT TO USE THIRD PARTY LASERS, SCANNERS, AND CAMERAS BUT ACTUAL PROJECT CONDITIONS, DIMENSIONS, AND ACCURACY OF MEASUREMENTS MAY DIFFER FROM THESE OR ANY PARAMETERS. RED LEONARD ASSOCIATES INC. ASSUMES NO LIABILITY FOR WHAT IS CREATED/PRODUCED IN THESE RECREATIONS. THIS INCLUDES BUT IS NOT LIMITED TO THE USE OF, INSTALLATION OF AND/OR INTEGRITY OF EXISTING BUILDING(S), SURROUNDING AREA FOR PRODUCT(S) SUCH AS EXISTING POLE(S), ANCHOR BOLT(S), BASE(S), ARCHITECTURAL AND SIGNAGE STRUCTURE(S), LANDSCAPING PLAN(S), LIGHTING PLAN(S), FIXTURE SELECTION(S) AND PLACEMENT, MATERIAL(S), COLOR ACCURACY, TEXTURE(S), AND ANYTHING ATTRIBUTED TO PHOTO REALISM THAT IS CREATED. FURTHERMORE, RED LEONARD ASSOCIATES INC., DOES NOT ASSUME LIABILITY WHATSOEVER FOR ANY PURCHASES MADE BY CLIENT BEFORE, DURING, OR AT THE CONCLUSION OF THE PUBLISHED WORK. THE CUSTOMER, ITS RELATIVE AFFILIATES, AS WELL AS ANY OTHER PERSON(S) IN VIEWING OF THIS PRODUCT IS RESPONSIBLE FOR VERIFYING COMPLIANCE WITH ANY BUT NOT LIMITED TO ALL CODES, PERMITS, RESTRICTIONS, INSTRUCTIONS, PURCHASES, AND INSTALLATIONS OF OBJECTS VIEWED WITHIN THIS DOCUMENT(S) OR PROJECT(S). SYMBOLS ARE NOT DRAWN TO SCALE. SIZE IS FOR CLARITY PURPOSES ONLY. SIZES AND DIMENSIONS ARE APPROXIMATE, ACTUAL MEASUREMENTS MAY VARY. DRAWINGS ARE NOT INTENDED FOR ENGINEERING OR CONSTRUCTION USE. THIS DOCUMENT, ANY RED LEONARD DRAWING(S), OR PROJECT(S) IS NOT TO BE USED AND/OR INTENDED FOR ENGINEERING OR CONSTRUCTION PURPOSES, BUT FOR ILLUSTRATIVE PURPOSES ONLY. ANY USE OF THIS DOCUMENTATION AND/OR OTHER ARTICLES PRODUCED BY RED LEONARD WITHOUT WRITTEN AUTHORIZATION FROM JAYME J. LEONARD IS STRICTLY PROHIBITED.



PROJECT NAME: SHEETZ BOONE, NC DRAWING NUMBER: RL-8231-S1-R4

